

GENERAL SYSTEM NOTES

- 1) FIRE ALARM SYSTEM IS POWER LIMITED. METALLIC RACEWAY SHALL BE USED IF REQUIRED BY CODE. SPECIFICATIONS AND CONTRACT DOCUMENTS OR AHJ.
- 2) ALL RACEWAYS MUST BE FREE OF JOIST/STUCCO
- 3) REFER TO SIMPLEX FIRE ALARM DATASHEETS FOR PROPER TYPE AND SIZES OF REQUIRED DEVICE MOUNTING ELECTRICAL BOXES. ELECTRICAL CONTRACTOR IS RESPONSIBLE FOR PROPER INSTALLATION OF ALL DEVICES.
- 4) AC VOLTAGE IS NOT PERMITTED IN THE SAME RACEWAY AS THE FIRE ALARM WIRING.
- 5) UNRELATED (NON-FIRE ALARM) WIRING SHALL NOT BE IN THE SAME RACEWAY AS FIRE ALARM WIRING.
- 6) ALL CONTRACTOR FIELD WIRING MUST ENTER TOP RIGHT AND/OR BOTTOM RIGHT OF FIRE ALARM CONTROL PANEL ONLY.
- 7) ZONE CIRCUITS AND SIGNAL CIRCUITS ARE ELECTRICALLY SUPERVISED. BRANCH CIRCUITS SHALL BE LOGGED TO MAINTAIN INTEGRITY OF SUPERVISED CIRCUITS—TAPPING OF SHALL BE LOGGED TO MAINTAIN INTEGRITY OF SUPERVISED CIRCUITS
- 8) REFER TO EACH MODEL AND SIGNAL CIRCUITS IS NOT PERMITTED
- 9) INFORMATION ON INDIVIDUAL PANEL INCLUDES WIRING IN PLACE, FOR SPECIFICATIONS AND FIELD TERMINATION, REPRESENTATIVE SAMPLE, LOGGED TO TERMINATION.
- 10) **ALL FIRE ALARM WIRING SHALL TEST FREE OF OPENES, SHORTS AND GROUNDS.**
- 11) ALL WIRING SHALL BE LABELED AND TAGGED
- 12) ELECTRICAL CONTRACTOR IS RESPONSIBLE FOR INSTALLATION AND MAKING ALL FINAL CONNECTIONS PRIOR TO JOB CHECKOUT AND FINAL TESTING BY A SIMPLEX FIELD TECHNICAL REPRESENTATIVE. CALL A MINIMUM OF 5 DAYS IN ADVANCE TO SCHEDULE A SIMPLEX TECHNICAL AT 827-3700.
- 13) ELECTRICAL CONTRACTOR IS RESPONSIBLE FOR MAKING ALL ARRANGEMENTS FOR INSPECTION, TEST AND CERTIFICATION OF THE FIRE ALARM SYSTEM BY ALL APPROPRIATE AUTHORITIES.
- 14) UPON WRITTEN REQUEST, SIMPLEX WILL PROVIDE WRITTEN INSTRUCTIONS REGARDING THE APPROPRIATE WIRE/CABLE FOR INSTALLATION OF THE EQUIPMENT/SYSTEM(S) IDENTIFIED IN THESE DRAWINGS. SIMPLEX SHALL NOT BE RESPONSIBLE FOR PROBLEMS OR DAMAGES RESULTING FROM THE USE OF WIRE/CABLE OTHER THAN THAT WHICH HAS BEEN IDENTIFIED IN WRITING BY SIMPLEX FOR A SPECIFIC APPLICATION.
- 15) ALL WIRING SHALL MEET ALL APPLICABLE NATIONAL ELECTRIC CODE ARTICLES FOR FIRE ALARM AND LOW VOLTAGE WIRING.

**ARCHITECT: BECKER ARCHITECTS
KIRKLAND, WA**

FIRE ALARM SYSTEM DESIGNED BY: INTERFACE ENGINEERS INC.
KIRKI AND WA

FIRE ALARM SYSTEM INSTALLATION BY: COPPER ELECTRIC
REDMOND, WA

*EQUIPMENT FOR FIRE ALARM SYSTEM BY: SIMPLEX TIME RECORDER CO
KIRKLAND, WA

• THESE DRAWINGS DO NOT SUPERSEDE THE CONTRACT DRAWINGS AND SPECIFICATIONS, THEY ARE INTENDED AS A SUPPLEMENT ONLY AND MUST BE USED IN CONJUNCTION WITH THE CONTRACT DOCUMENTS. THEY DO NOT MODIFY THE CONTRACTORS OBLIGATIONS TO CONFORM TO THE PROJECTS ORIGINAL DESIGN CRITERIA.

© 1987 Simplex Time Recorder Co.
Gardner, MA. 01441


L/O POINTS		CIRCUIT DESCRIPTION		CIRCUIT (A)		SW/BE RUN (FT)		CIRCUIT VOROP	
1	MAIN FLOOR WEST & EAST STROBES	0	555	600	1,6720				
2	MAIN FLOOR CENTER STROBES	0	565	420	0.911				
3	STAGE, ORCHESTRA & ARTS STROBES	1,140		620	2,304				
4	VOICE CONTROL PANEL								
5-8	NOT USED								
9	RELEASE DOOR HOLDERS								
10	GLOBAL FAN SHUTDOWN								
11	LIGHTING CONTROL PANEL								
12	SECURITY CONTROL SYSTEM								
13	SMOKE REMOVAL SYSTEM								
14	SPRINK								
15	SPRINK								
16	SPRINK								

<u>VOICE CONTROL PANEL</u>		
<u>CIRCUIT</u>	<u>CIRCUIT DESCRIPTION</u>	<u>CIRCUIT LOAD(W)</u>
1	MAIN FLOOR WEST & EAST SPEAKERS	9 WATTS
2	MAIN FLOOR CENTER SPEAKERS	5 WATTS
3	STAGE, ORCHESTRA & ARTS SPEAKERS	10 WATTS
4	SPARE	

VOICE CONTROL PANEL

	CIRCUIT DESCRIPTION
1	MAIN FLOOR WEST & EAST SPEAKERS
2	MAIN FLOOR CENTER SPEAKERS
3	STAGE, ORCHESTRA & ARTS SPEAKERS
4	SPARE

ADDRESSABLE DETECTOR IDENTIFICATION

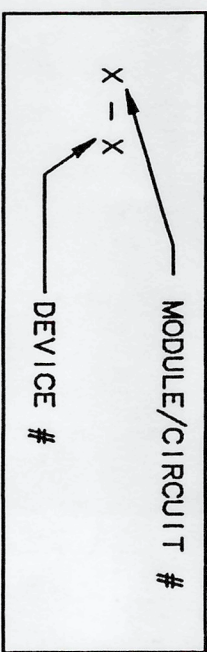


MAPNET CIRCUIT DISTRIBUTION

DO NOT EXCEED 2500ft AIT TO ELIMINATE

LEGEND

SYMBOL	DESCRIPTION	MODEL #	BACK BOX
	MANUAL PULL STATION • SUBSCRIPT INDICATES AMBERT #	2099-9795W/ 2099-981.3 TRIM	2-GANG DEEP BY EC 3" X 2" X 2.5"
	SPEAKER/STROBE 15/75cd • SUBSCRIPT INDICATES AMBERT #	4903-9326	4" SQ BY EC
	STROBE 15/75 cd • SUBSCRIPT INDICATES CURRENT #	4904-9305	SG DEEP BY EC
	TRUEALARM SMOKE DETECTOR • SUBSCRIPT INDICATES AMBERT #	4098-9701 W/ 4098-9784 BASE	4" OCT BY EC
	TRUEALARM HEAT DETECTOR • SUBSCRIPT INDICATES AMBERT #	4098-9732 W/ 4098-9784 BASE	4" OCT BY EC
	DUCT SMOKE DETECTOR W/ REMOTE LED W/TEST • SUBSCRIPT INDICATES AMBERT #	4098-9706 W/ 2098-9806	SELF-CONTAINED SINGLE GANG BY EC
	FLOW SWITCH	BY OTHERS	BY OTHERS
	TAMPER SWITCH	BY OTHERS	BY OTHERS
	POST INDICATOR VALVE	BY OTHERS	BY OTHERS
	REMOTE RELAY	2088-9007	SELF-CONTAINED
	SUPERVISED IAM	2190-9172	4" SQ DEEP W/COVER BY EC
	REMOTE PRINTER 24V	2190-9039	TABLE TOP
	VOICE CONTROL PANEL	4003-9092	20.75" X 25.75" X 4.25"
	BATTERY CABINET	2081-9281	20.75" X 25.75" X 6.75"
	DOOR HOLDER	2088-9588	SG BY EC
	SMOKE/FIRE DAMPER	BY OTHERS	BY OTHERS
	LCD ANNUNCIATOR	4603-9101	5-GANG BOX 3.5" DEEP BY EC
	FIRE ALARM CONTROL PANEL	4002-9001	52.125" X 25.75" X 4.25"

SEQUENCE OF OPERATION	MANUAL PULL STATION	SMOKE DETECTION	DUCT SMOKE DETECTION	HEAT DETECTION	FLOW SWITCH	TAMPER SWITCH	POST INDICATOR VALVE	SYSTEM TROUBLE
ACTIVATION OF LOCAL ALARM AT TAP (LCD DISP. & AUDIBLE INDICATION)	X	X	X	X	X			
DISPLAY ALARM AT ANNUNCIATOR	X	X	X	X	X			
ACTIVATE ALL ADDRESSABLE DEVICES	X	X	X	X	X			
RELEASE DOOR HOLDERS	X	X	X	X	X			
GLOBAL FAN SHUTDOWN	X	X	X	X	X			
CLOSE SMOKE/FIRE DAMPERS	X	X	X	X	X			
TRANSMIT SIGNAL TO TURN-ON LIGHTS	X	X	X	X	X			
TRANSMIT SIGNAL TO SECURITY CONTROL SYSTEM	X	X	X	X	X			
SECURITY CONTROL SYSTEM TO SMOKE REMOVAL SYSTEM	X	X	X	X	X			
TRANSMIT ALARM SIGNAL TO CENTRAL STATION MONITOR	X	X	X	X	X			
PROBLE/SUPV. INDICATION AT KAP						X	X	X
PROBLE/SUPV. INDICATION AT ANNUNCIATOR						X	X	X
TRANSMIT PROBLE/SUPV. SIGNAL TO CENTRAL STATION MONITOR						X	X	X

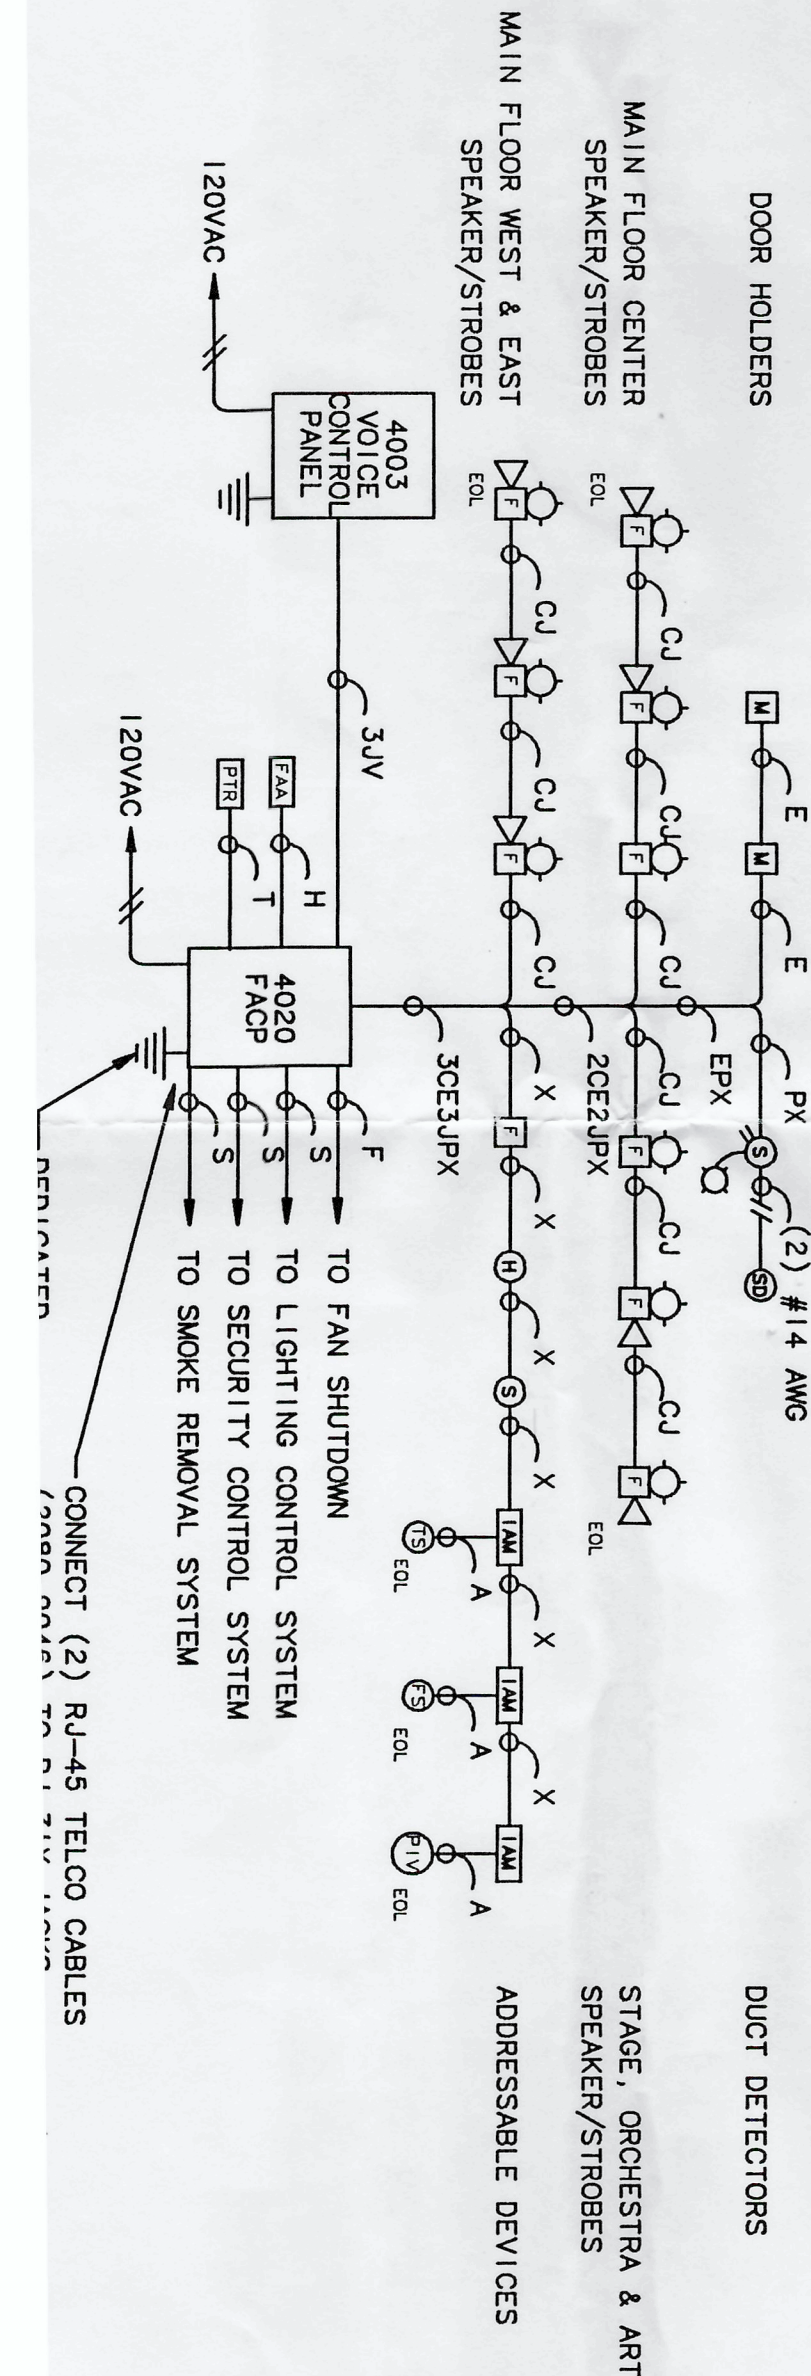**WIRE CODE**

ALL WIRING TO MEET CURRENT NATIONAL ELECTRIC
CODE ARTICLE 760, 300, 310, 370, 725 AND ALL RELATED
SECTION CODE REQUIREMENTS

LETTER	QTY	COLOR/TYPE	SIZE	FUNCTION
A	2	BLACK/ORANGE	1/8	ZONE
C	2	RED/BLUE THHN	1/4	STROBE
E	2	BROWN/YELLOW THHN	1/4	DOOR HOLDERS
F	2	ORANGE/YEL./BLACK/BLUE THHN	1/4	FAN SHUTDOWN
H	1	WEST PENN 0975	1/8	SERIAL ANNUNCIATOR
	2	RED/BLACK THHN	1/4	
J	1	TM/SHLD. PAIR	1/8	SPEAKER
P	2	RED/BLACK THHN	1/4	24VDC POWER
R	2	BLUE/WHITE TFN	1/6	REMOTE LED W/TEST
	2	PINK TFN	1/6	
S	2	PURPLE/WHITE THHN	1/4	FACP SIGNALS
T	1	WEST PENN 0975	1/8	PRINTER
V	2	WEST PENN 0975	1/8	VOICE CONTROL PANEL
	2	RED/BLACK THHN	1/4	
	2	RED/BLUE THHN	1/4	
X	1	WEST PENN 0975	1/8	ADDR. MAPNET DATA LINE

- 1) TAG AND IDENTIFY ALL ZONE WIRES WITH ZONE NUMBER
- 2) TAG AND IDENTIFY ALL SIGNAL CIRCUIT WIRES WITH SIGNAL CIRCUIT NUMBER.
- 3) TAG AND IDENTIFY ALL ANNUNCIATOR WIRES.

BATTERY CALCULATIONS

DOES THE SYSTEM HAVE AN EMERGENCY GENERATOR THAT MEETS NEC 700.701 ☐ YES ☒ NO?

HOW MANY HOURS OF BATTERY STANDBY ARE REQUIRED? ☐ 4 ☒ 24 ☐ 48 ☐ 60 (4 HRS. MIN. W/EMER. GEN.)

QTY	PART #	DESCRIPTION	STANDBY CURRENT (A)	TOTAL STANDBY (A)	ALARM CURRENT (A)	TOTAL ALARM (A)
2	4020-0023	FIRE ALARM CONTROL PANEL	0.5000	0.5000	0.4400	0.4400
1	4020-0035	8 POINT 7.5 OHM CARD	0.1000	0.2000	0.3500	0.5500
1	4020-0110	RESEARCH	0.3000	0.3000	0.2300	0.3300
1	4020-0101	LOG ALARM/NOTIFY	0.0500	0.0500	0.1700	0.1200
21	4020-0033	STROBE	0.0200	0.4200	0.0500	1.0500
6	4020-0033	STROBE	0.0500	0.3000	0.0500	0.3000
2	2100-0033	PRINTERS	0.5000	0.5000	1.2000	1.5000
1	4020-0033	STROBE	0.0500	0.0500	0.0500	0.1000
1	4020-0033	STROBE	0.0500	0.0500	0.0500	0.1000
17	4020-0071	DIAGNOSTIC DETECTOR	0.0003	0.0051	0.0250	0.4270
4	2098-0007	1M 01 RELAY	0.0000	0.0000	0.0150	0.0600
Total Standby=			1.5881			
Total Alarm=					6.2680	
Total Standby Current Required			1.5881 X			
Total Alarm Current Required			6.2680 X			
Total					0.1867	
20% Depleation Factor						
Total Any/hour Required						37.5344
Total Any/hour Batteries Provided						1.0445
						38.6789
						7.7588
						46.4147
						50.0000

NOTES:

- FIRE ALARM DRUMS ARE SCHEDULED ONLY.
- ALL CABLE SUBSTITUTIONS MUST BE APPROVED BY SIMPLEX ENGINEERING IN WRITING.
- NOTE: MOUNT HORN/STROBES, SPEAKER/STROBES AND STROBES AT 80° TO BOTTOM OF DEVICE.
- NOTE: MOUNT PULL STATIONS AT 48" TO TOP OF DEVICE.
- ALL SHIELDS ON THE SAME MARKET CHANNEL SHALL BE TIED TOGETHER AND BE FREE OF OPENS, SHORTS, AND GROUND.
- DO NOT EXCEED 2500 FT OUT TO FURTHEST DEVICE- MAXIMUM 10,000 FT ON MARKET CHANNEL.
- DRY CONTACT ONLY PROVIDED FOR DOOR DAMPERS, ROLLERS AND SMOKE/FIRE DAMPERS - POWER BY OTHERS.


ЕЛЕКТРИКАЛ КОНТРАСТОР

[illegible]





FIRE ALARM SYSTEM COVER SHEET

KIRKLAND PERFORMANCE CENTER

406 KIRKLAND AVENUE
KIRKLAND, WA

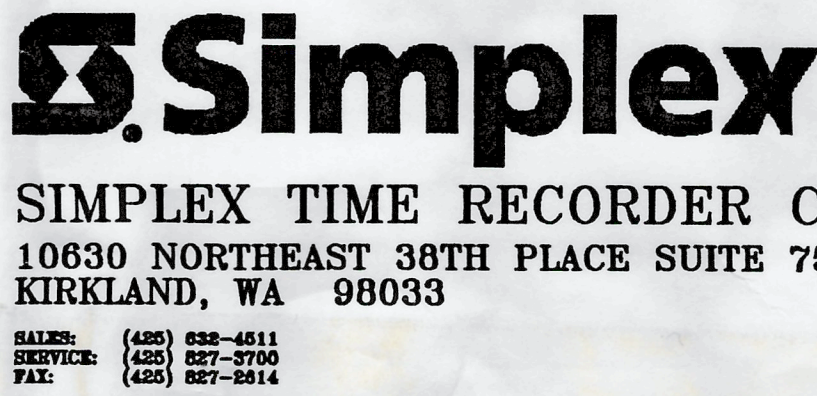

SIMPLEX TIME RECORDER CO.
10630 NORTHEAST 38TH PLACE SUITE 75
KIRKLAND, WA 98033

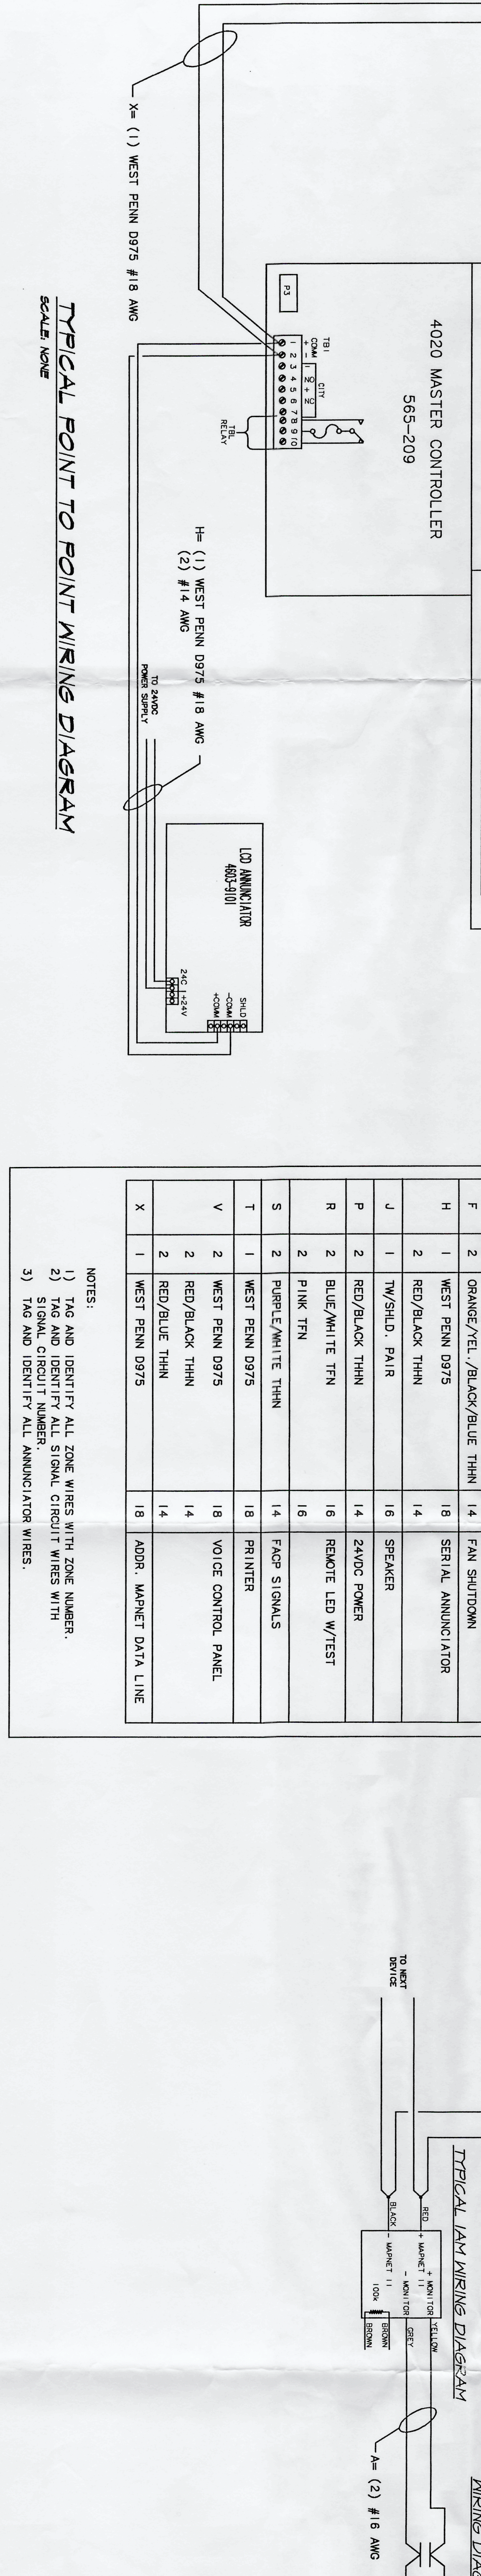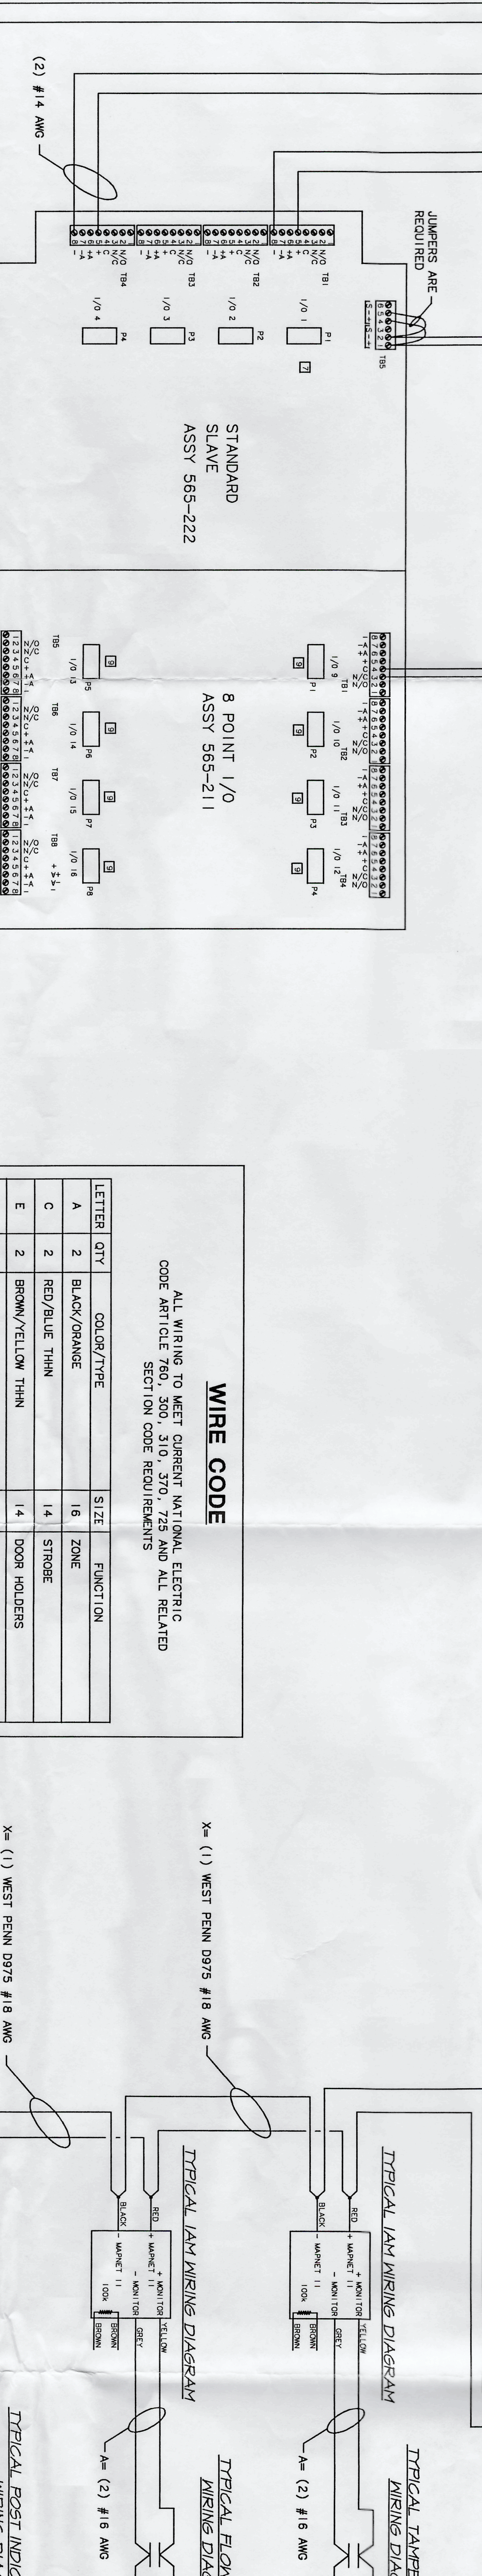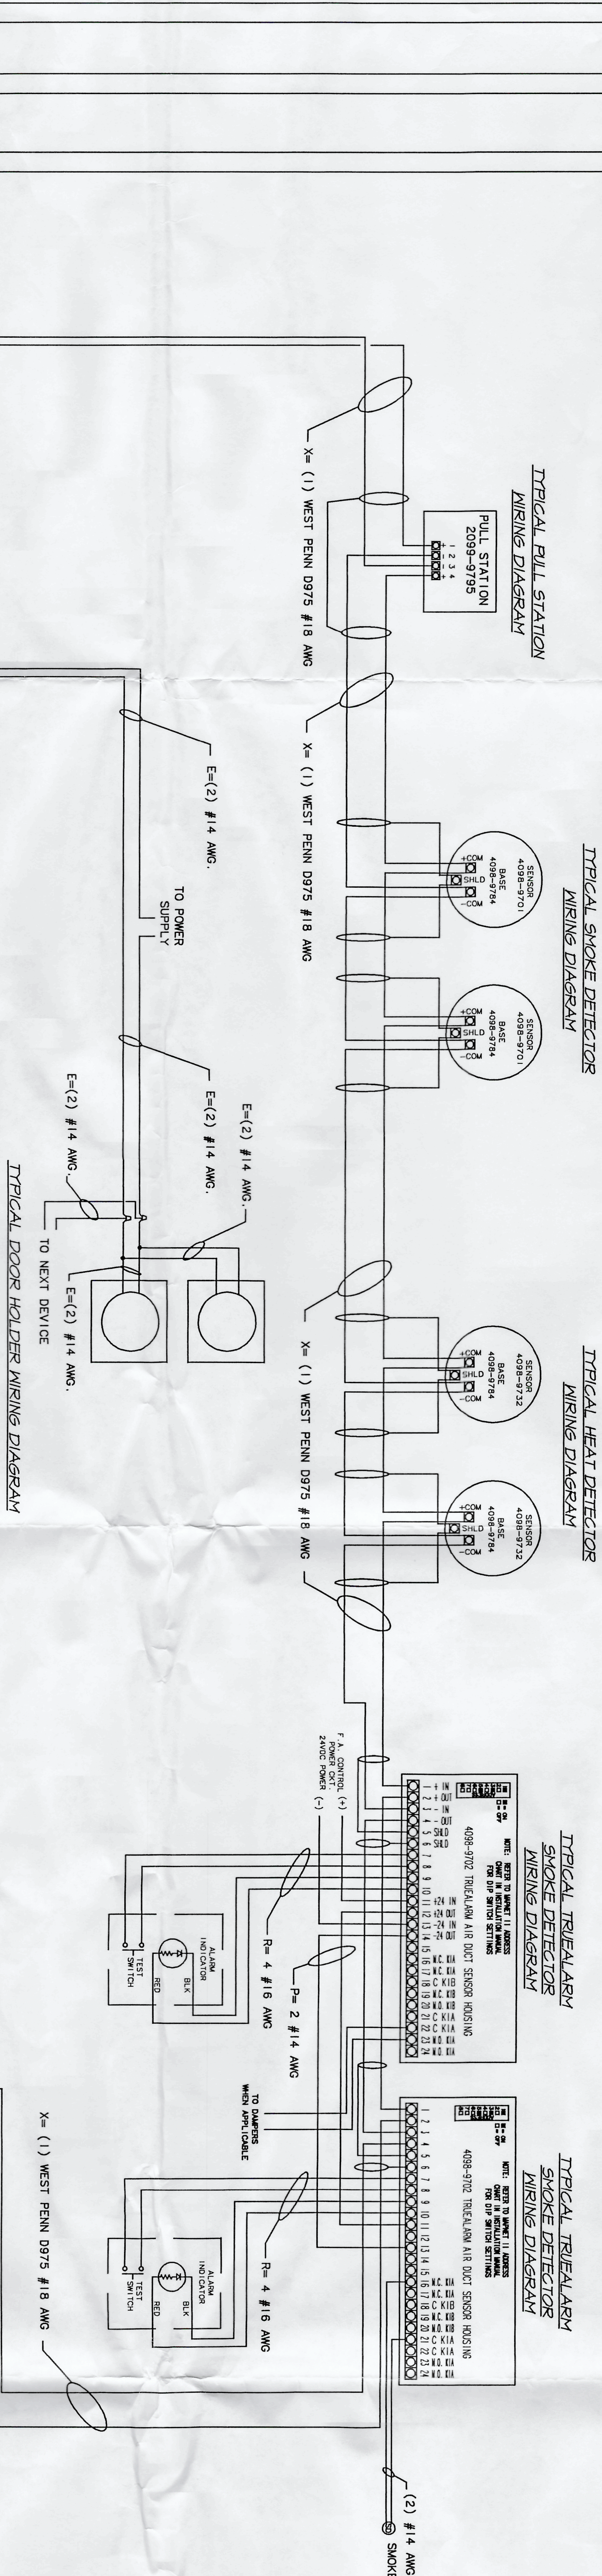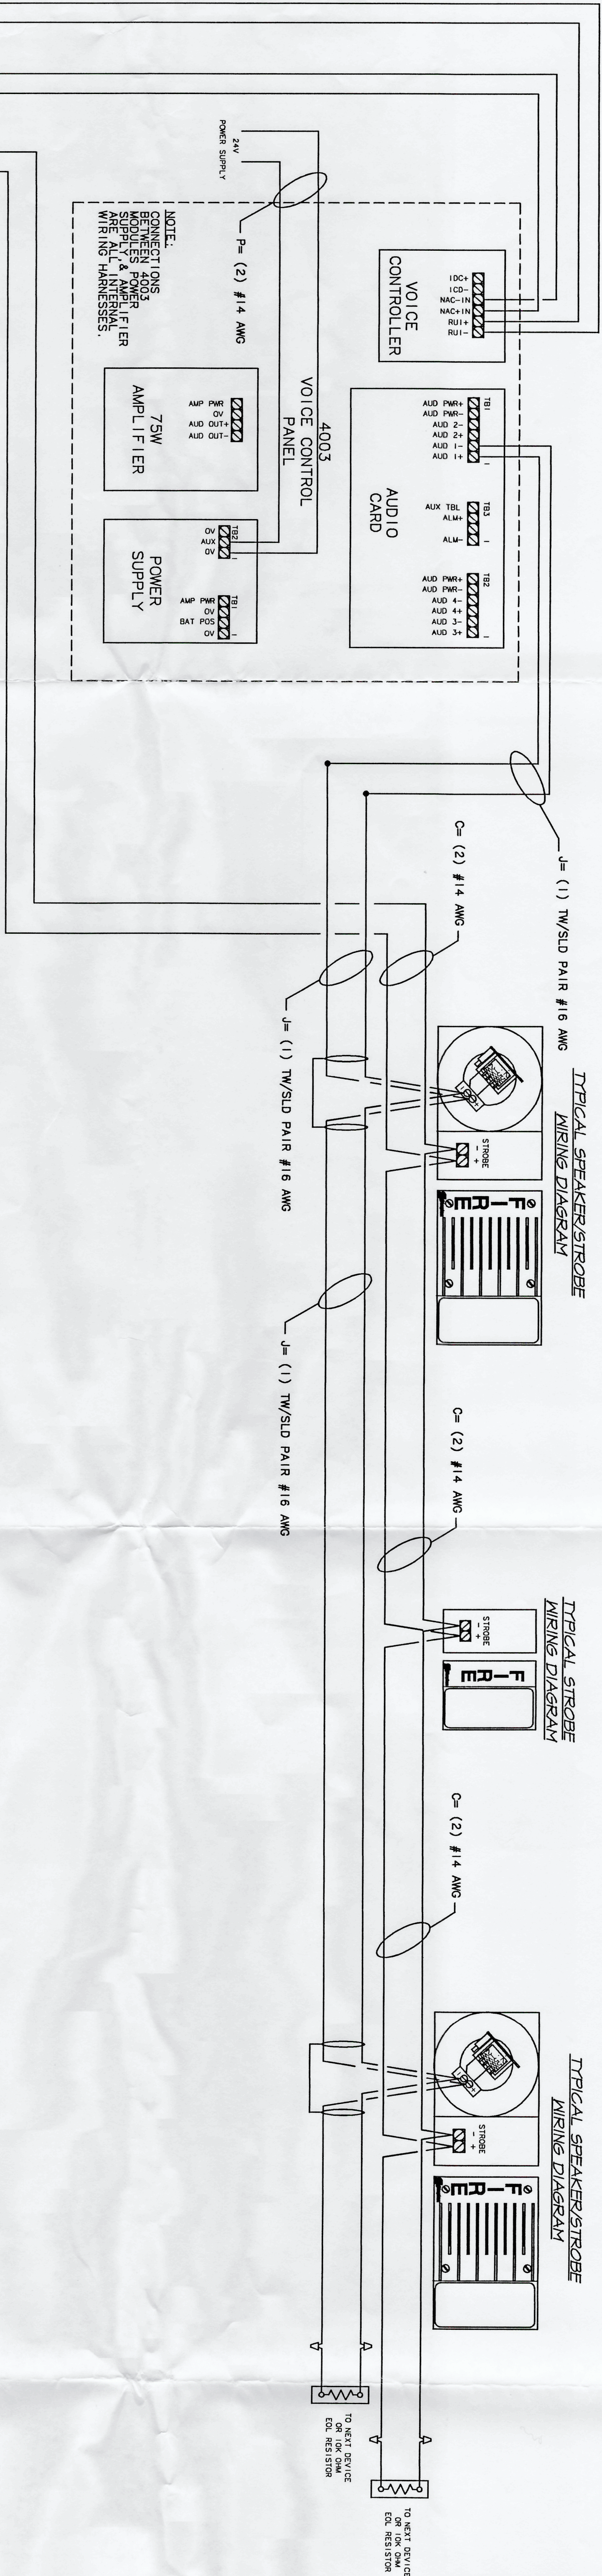

WIRE CODE			
ALL WIRING TO MEET CURRENT NATIONAL ELECTRIC CODE ARTICLE 760, 300, 310, 370, 725 AND ALL RELATED SECTION CODE REQUIREMENTS			
LETTER	QTY	COLOR/TYPER	SIZE FUNCTION
A	2	BLACK/ORANGE	16 ZONE
C	2	RED/BLUE THHN	14 STROBE
E	2	BROWN/YELLOW THHN	14 DOOR HOLDERS
F	2	ORANGE/YEL./BLACK/BLUE THHN	14 FAN SHUTDOWN
H	1	WEST PENN D975	18 SERIAL ANNUNCIATOR
J	1	RED/BLACK THHN	16 SPEAKER
P	2	RED/BLACK THHN	14 24VDC POWER
R	2	BLUE/WHITE TFN	16 REMOTE LED W/TEST
S	2	PURPLE/WHITE THHN	14 FACE SIGNALS
T	1	WEST PENN D975	18 PRINTER
V	2	WEST PENN D975	18 VOICE CONTROL PANEL
X	1	WEST PENN D975	18 ADDR. MARKET DATA LINE

ISSUE RECORD

NO.	DATE	BY	REVISION
1	8/14/97	M.C.E.	1

APPROVED BY:

APPROVED BY:

DATE:

8/14/97

DESIGN BY:

M.C.E.

REVISION INFORMATION

SHIFTEX PROJECT NUMBER

4556700/901

SHEET TITLE:

DETAILS

SHEET NUMBER:

2

OF 4

FIRE ALARM SYSTEM

DETAIL WIRING DIAGRAM

KIRKLAND PERFORMANCE CENTER

406 KIRKLAND AVENUE

KIRKLAND, WA.

Simplex

SIMPLEX TIME RECORDER CO.

10630 NORTHEAST 38TH PLACE SUITE 75

KIRKLAND, WA 98033

10630 NORTHEAST 38TH PLACE SUITE 75



KIRKLAND, WA 98033

LEGEND		
SYMBOL	DESCRIPTION	MODEL #
	MANUAL PULL STATION	2099-9795W/
	SPEAKER/STROBE 15/750d	2099-9813 TRIM
	STROBE 15/750d	4903-9326
	TRUEALARM SMOKE DETECTOR	4904-9305
	TRUEALARM HEAT DETECTOR	4098-9701 W/SE
	DUCT SMOKE DETECTOR W/ REMOTE LED W/TEST	4098-9732 W/ 4098-9784 BASE
	FLOW SWITCH	2098-9806
	TAPER SWITCH	BY OTHERS
	POST INDICATOR VALVE	BY OTHERS
	REMOTE RELAY	2098-9007
	SUPERVISORY I AM	2190-9172
	REMOTE PRINTER 24V	2190-9039
	VOICE CONTROL PANEL	4003-9002
	DOOR HOLDER	2081-9281
	SMOKE/FIRE DAMPER	2098-9599
	LCD ANNUNCIATOR	4603-9101
	FIRE ALARM CONTROL PANEL	4002-9001

LETTER	QTY	COLOR/TYPER	SIZE	FUNCTION
A	2	BLACK/GRANGE	1/8	ZONE
C	2	RED/BLUE THHN	1/4	STROBE
E	2	BROWN/YELLOW THHN	1/4	DOOR HOLDERS
F	2	ORANGE/YEL./BLACK/BLUE THHN	1/4	FAN SHUTDOWN
H	1	WEST PENN D975	1/8	SERIAL ANNUNCIATOR
J	1	TW/SHLD. PAIR	1/6	SPEAKER
P	2	RED/BLACK THHN	1/4	24VDC POWER
R	2	BLUE/WHITE TFN	1/6	REMOTE LED W/TEST
S	2	PURPLE/WHITE THHN	1/4	FAOP SIGNALS
T	1	WEST PENN D975	1/8	PRINTER
V	2	WEST PENN D975	1/8	VOICE CONTROL PANEL
X	2	RED/BLACK THHN	1/4	
X	2	RED/BLUE THHN	1/4	
X	1	WEST PENN D975	1/8	ADDR. MAGNET DATA LINE

- NOTES:
- 1) TAG AND IDENTIFY ALL ZONE WIRES WITH ZONE NUMBER.
 - 2) TAG AND IDENTIFY ALL SIGNAL CIRCUIT WIRES WITH SIGNAL CIRCUIT NUMBER.
 - 3) TAG AND IDENTIFY ALL ANNUNCIATOR WIRES.

ADDRESSABLE DETECTOR IDENTIFICATION

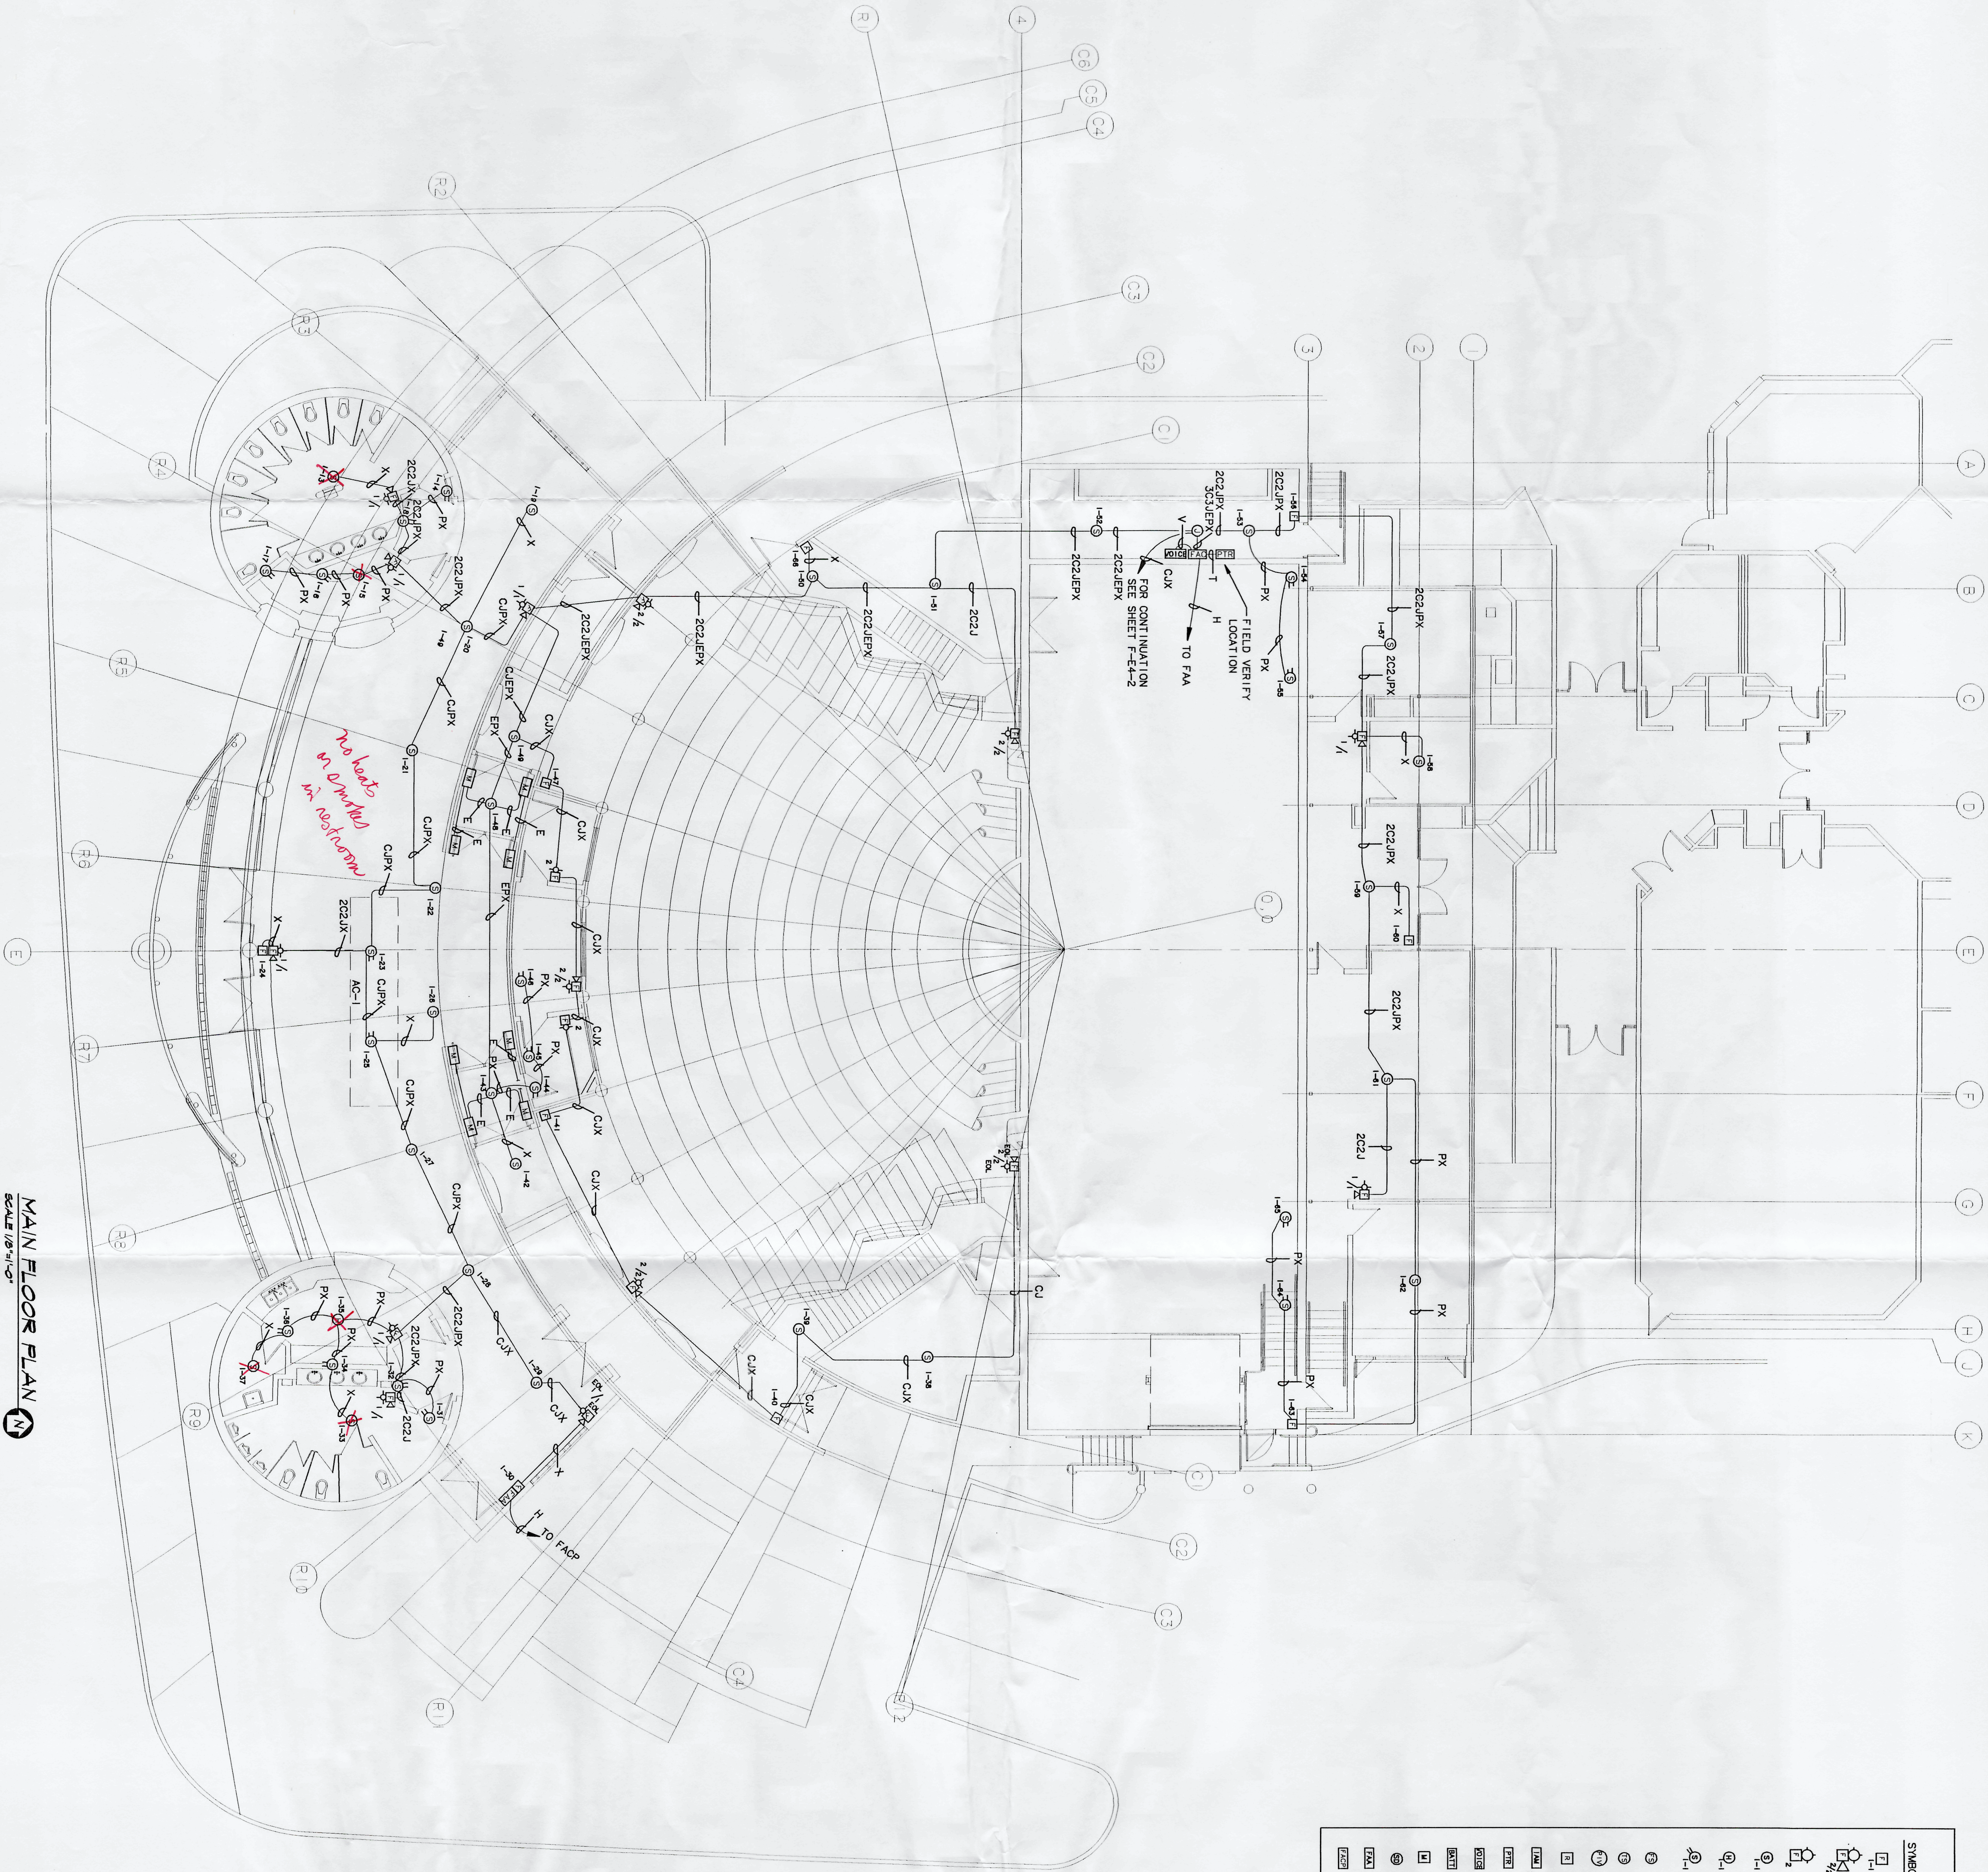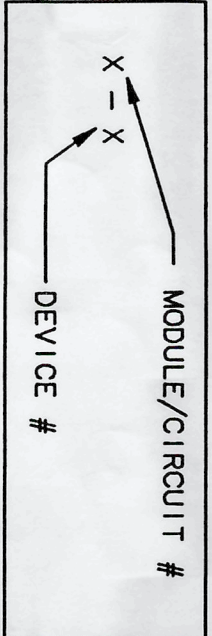

MAIN FLOOR PLAN

SCALE 1/8"=1'-0"

Simplex

SIMPLEX TIME RECORDER CO.
10630 NORTHEAST 38TH PLACE SUITE 75
KIRKLAND, WA 98033

FIRE ALARM SYSTEM
MAIN FLOOR PLAN

KIRKLAND PERFORMANCE CENTER

406 KIRKLAND AVENUE
KIRKLAND, WA

ISSUE RECORD

DATE

DESCRIPTION

DRAWN BY:
SAL
DATE:
8-14-97
APPROVED BY:
H.D.
SIMPLEX PROJECT NUMBER
45897007901

SHEET TITLE:
F-E4-1

SHEET NUMBER:
3

OF 4

